





給水管取出し標準図及び給水管資材表
S = FREE

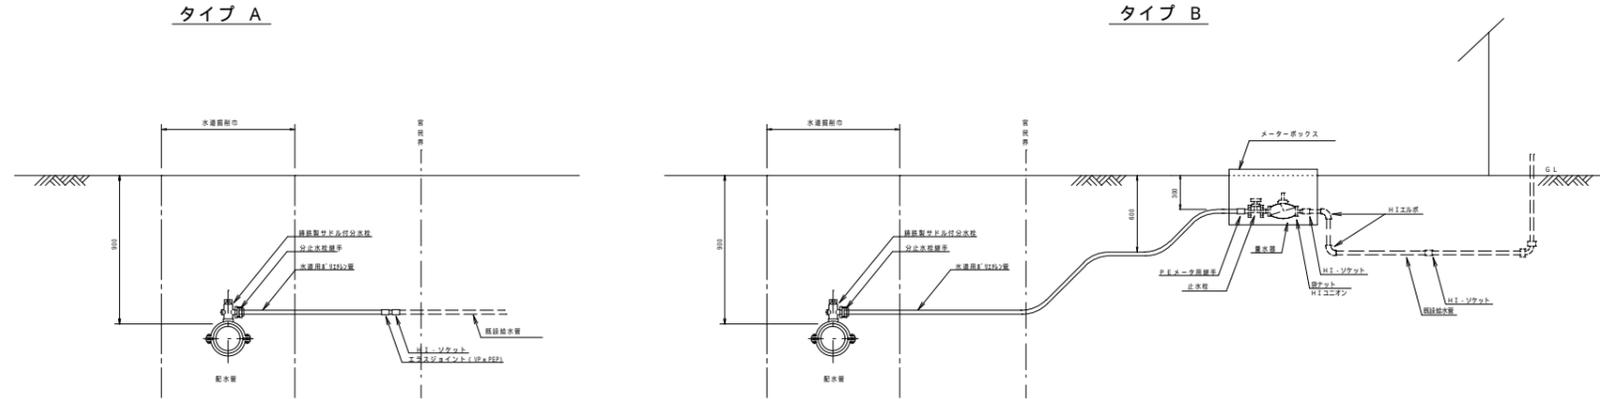




給水管資材表

氏名	資材 タイプ	サドル付分水栓 (VP用)						分止水栓用継手			PEメータ用継手			水導管φ119用			エラストジョイント (VP x PEP)			ブッシング			HI-ソケット				止水栓			メータボックス	量水器 (支給品)			計-017 計作-		土 工				備 考		
		75 x 20	75 x 25	75 x 30	100 x 20	100 x 25	100 x 30	20	25	30	13	20	25	20	25	30	20	25	30	13	20	25	30	20	25	20 x 13	13	20	25	A (明通AS)	B (埋込)											
1	A					1			1									5.5		1													5.5	5.5								
2	B					1			1			1						4.7															4.7	3.2	1.5							
3																																										
4																																										
5																																										
6																																										
	計					1	1		1	1		1					4.7	5.5		1													10.2	8.7	1.5							



配水管

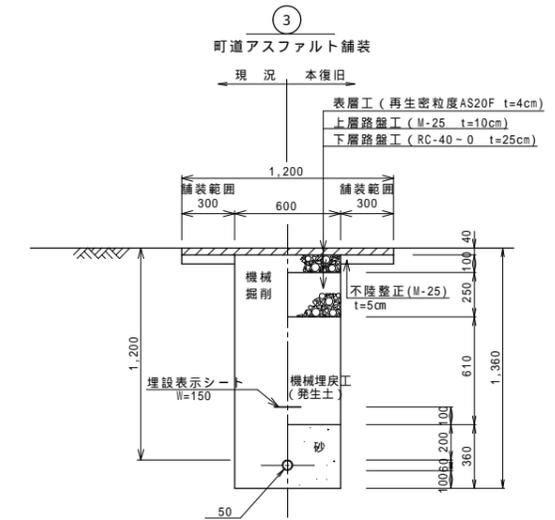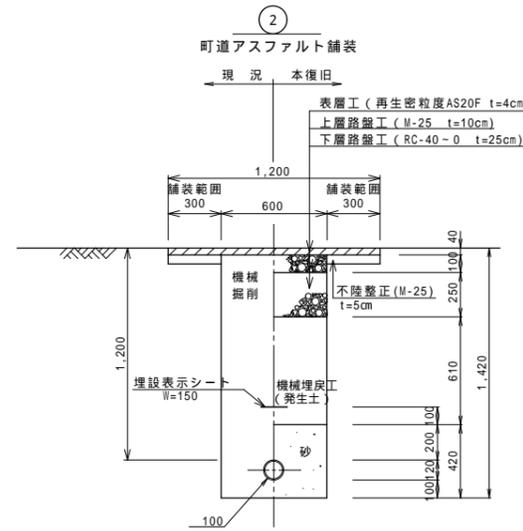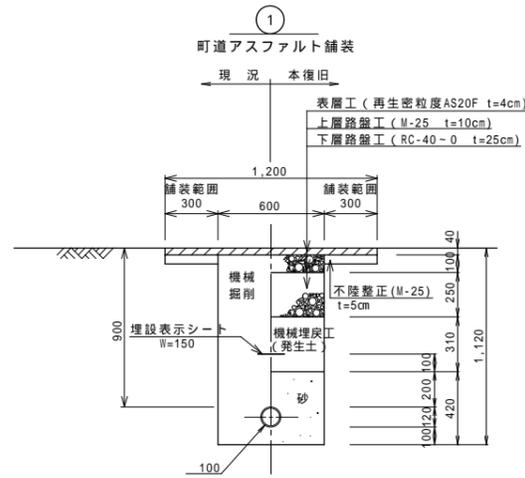


給水管

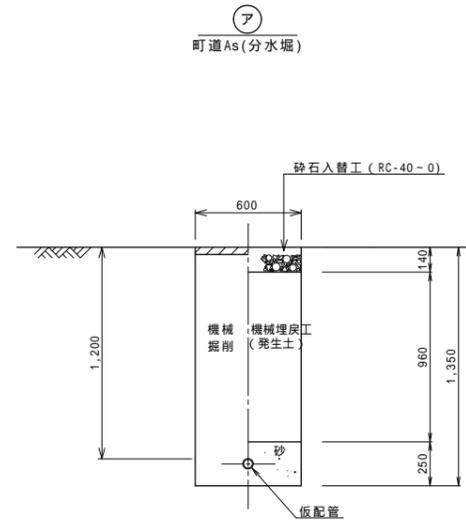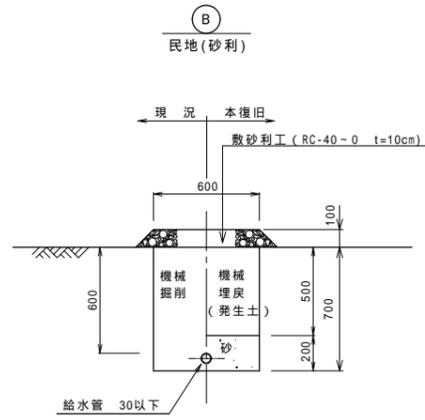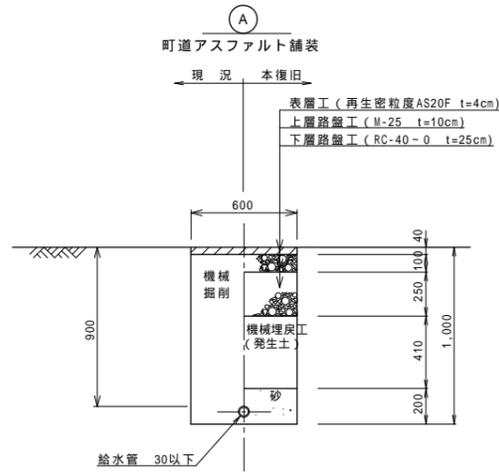


仮配管

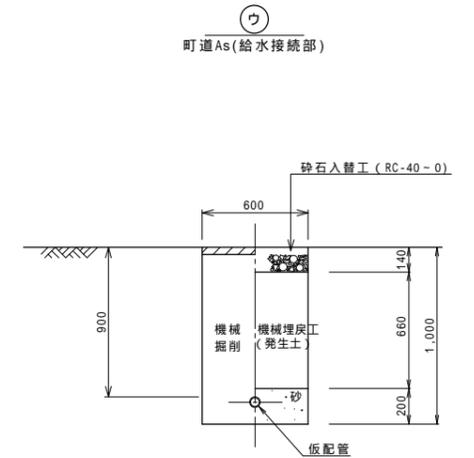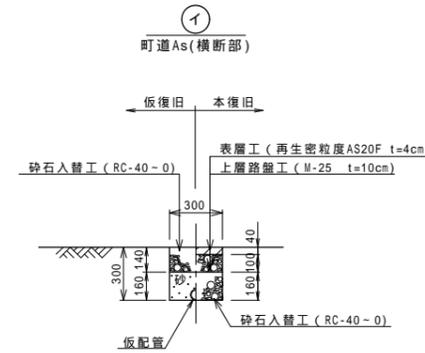

令和元年度			
上水道管布設替工事(1工区)			
標準掘削断面図 縮尺 図示			
箕輪町 松島			
照査	設計	製図	
図面番号 4 葉中之 3			
箕輪町役場			

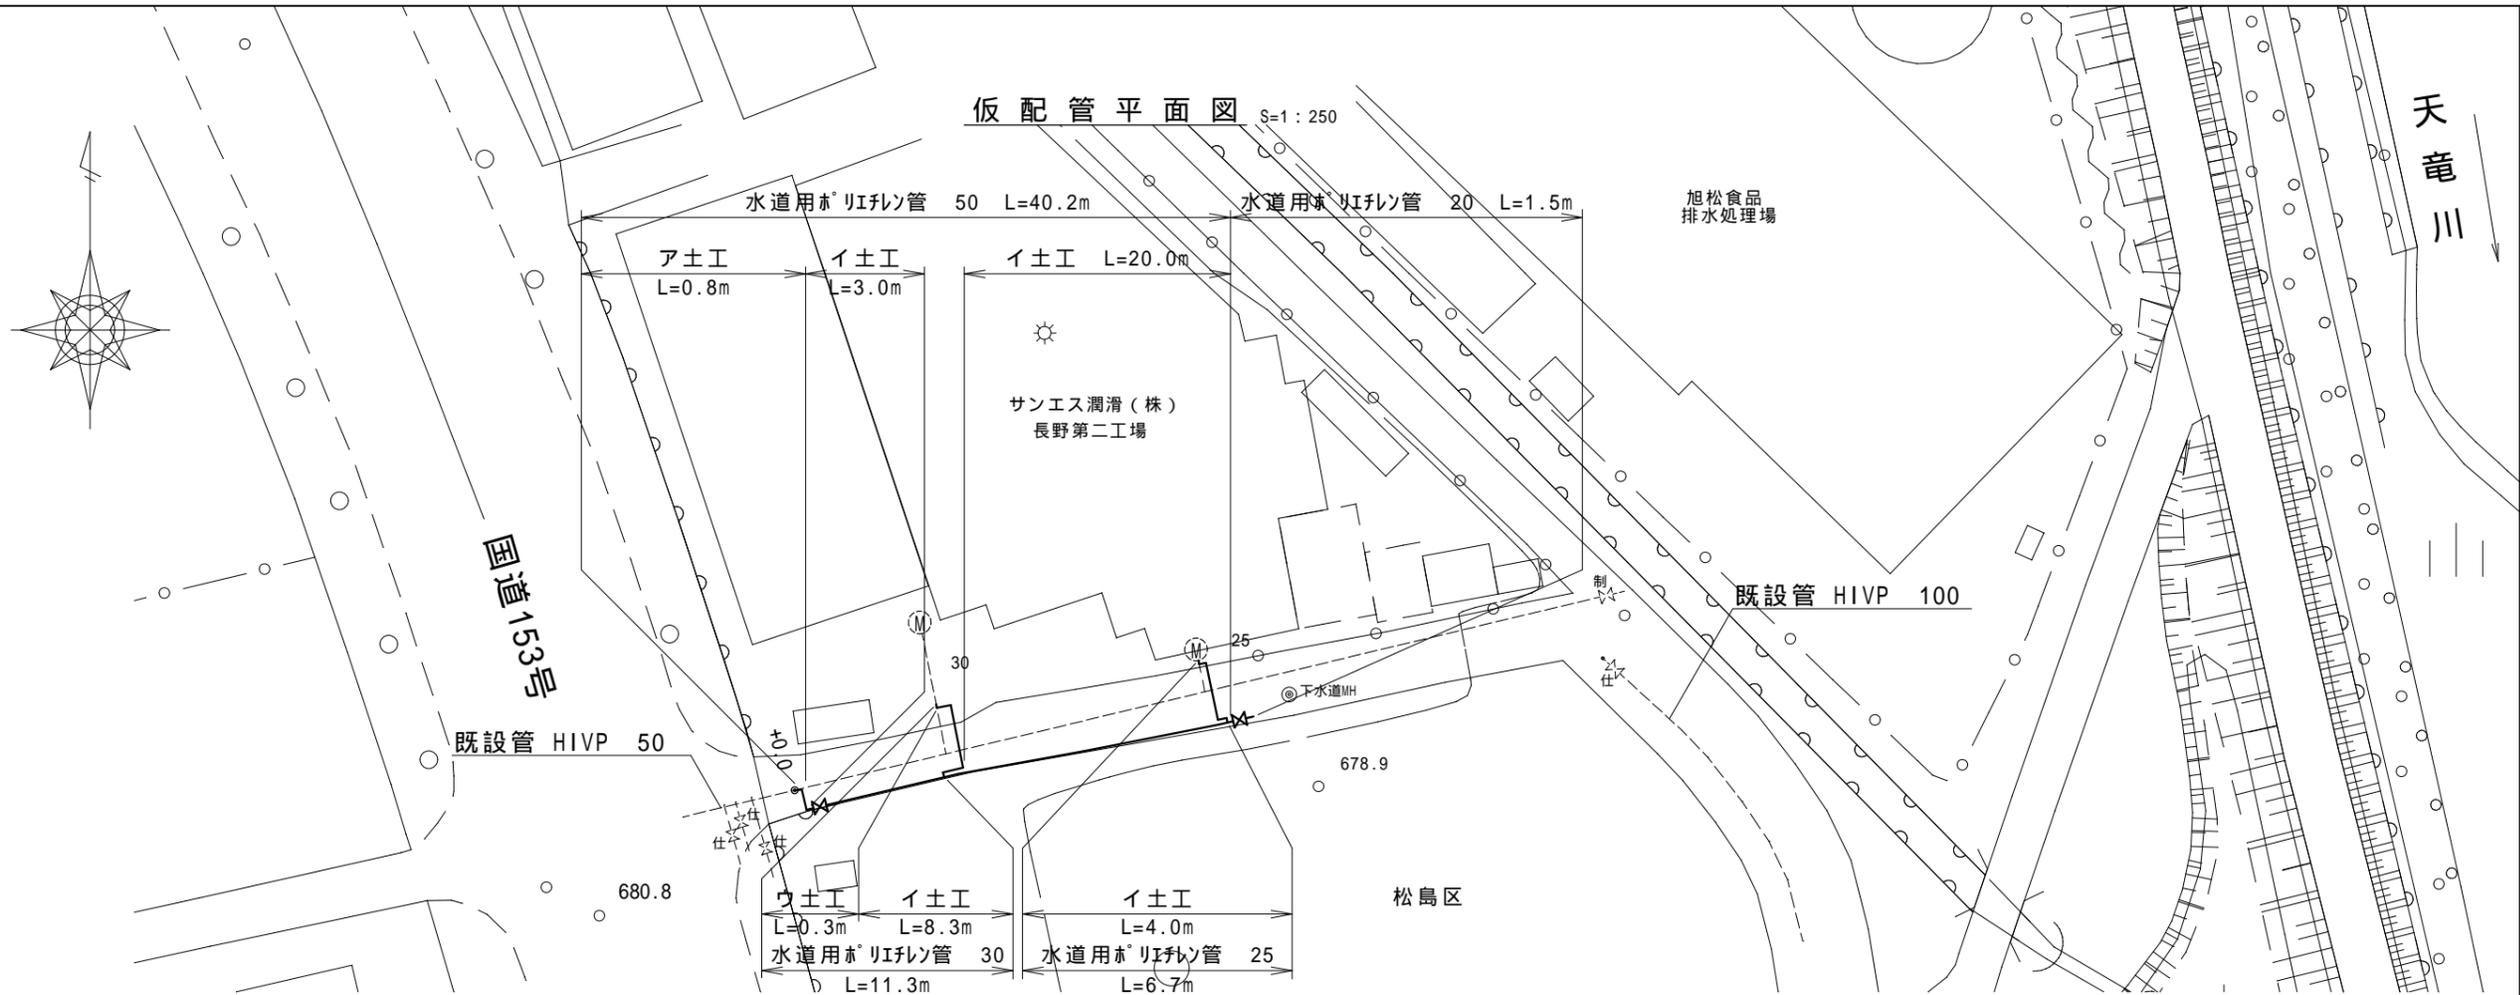

仮配管詳細図 S=FREE

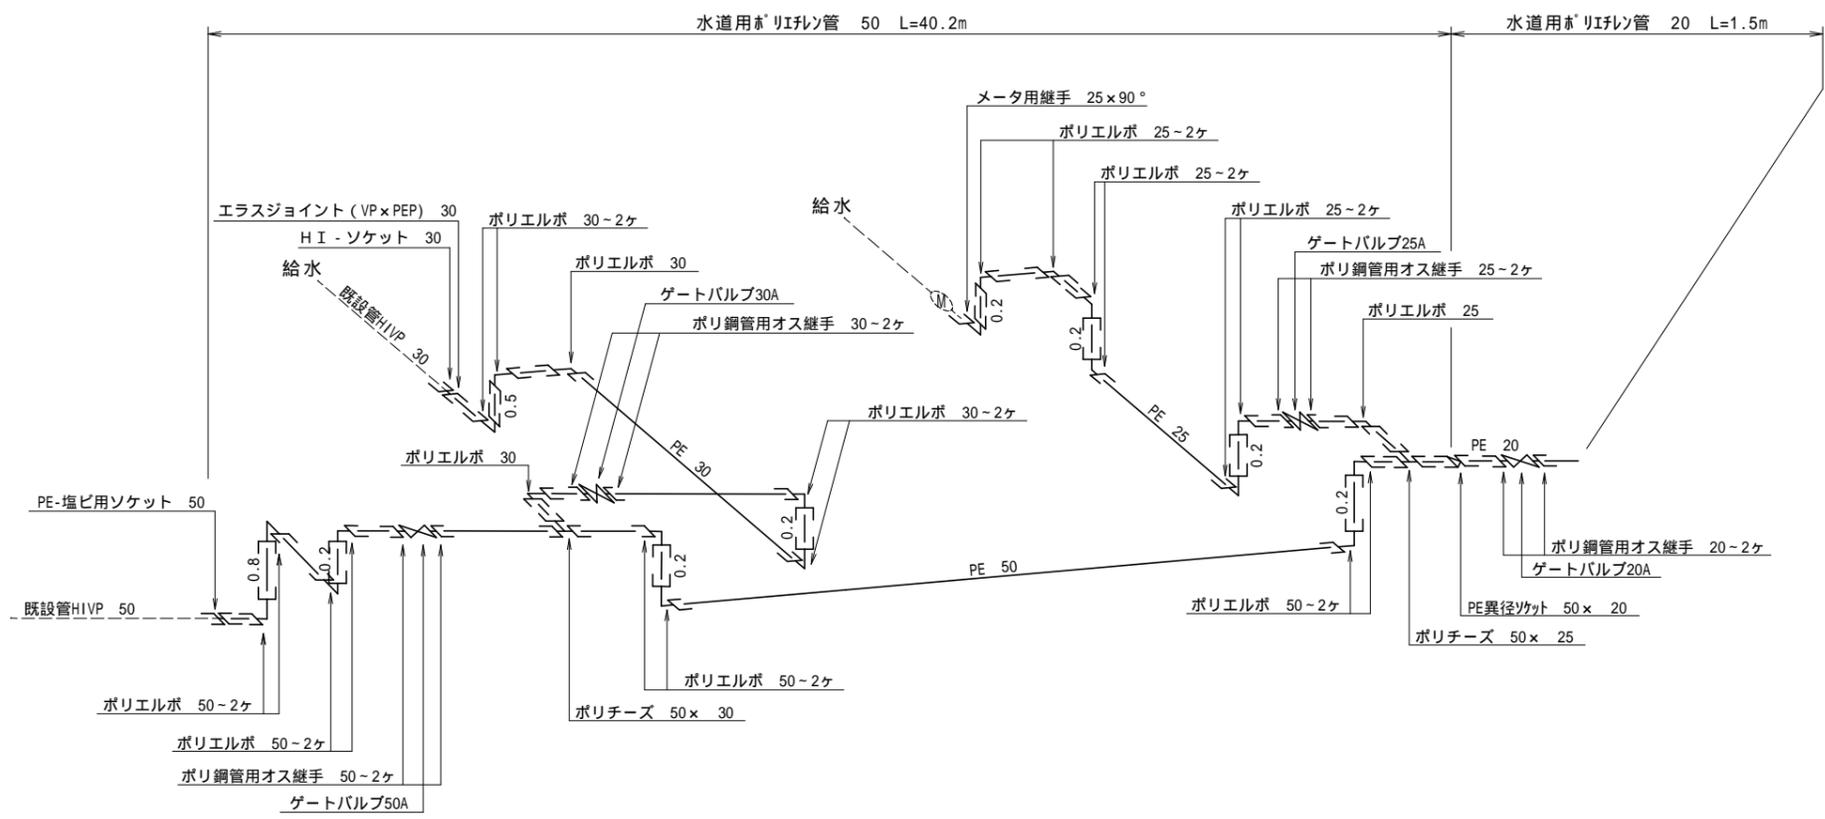

令和元年度		
上水道管布設替工事(1工区)		
仮配管平面図	縮尺	図示
及び仮配管詳細図		
箕輪町 松島		
照査	設計	製図
図面番号	4	葉中之 4
箕輪町役場		